




City and Guilds 2396 Design of Electrical Installations

Ogbourne Town FC
Proposed New Changing Rooms,
Clubhouse & MUGAs

2396-401
Project
2018/2019

Drawing Number 2396-2018/19/1 Floor Plan

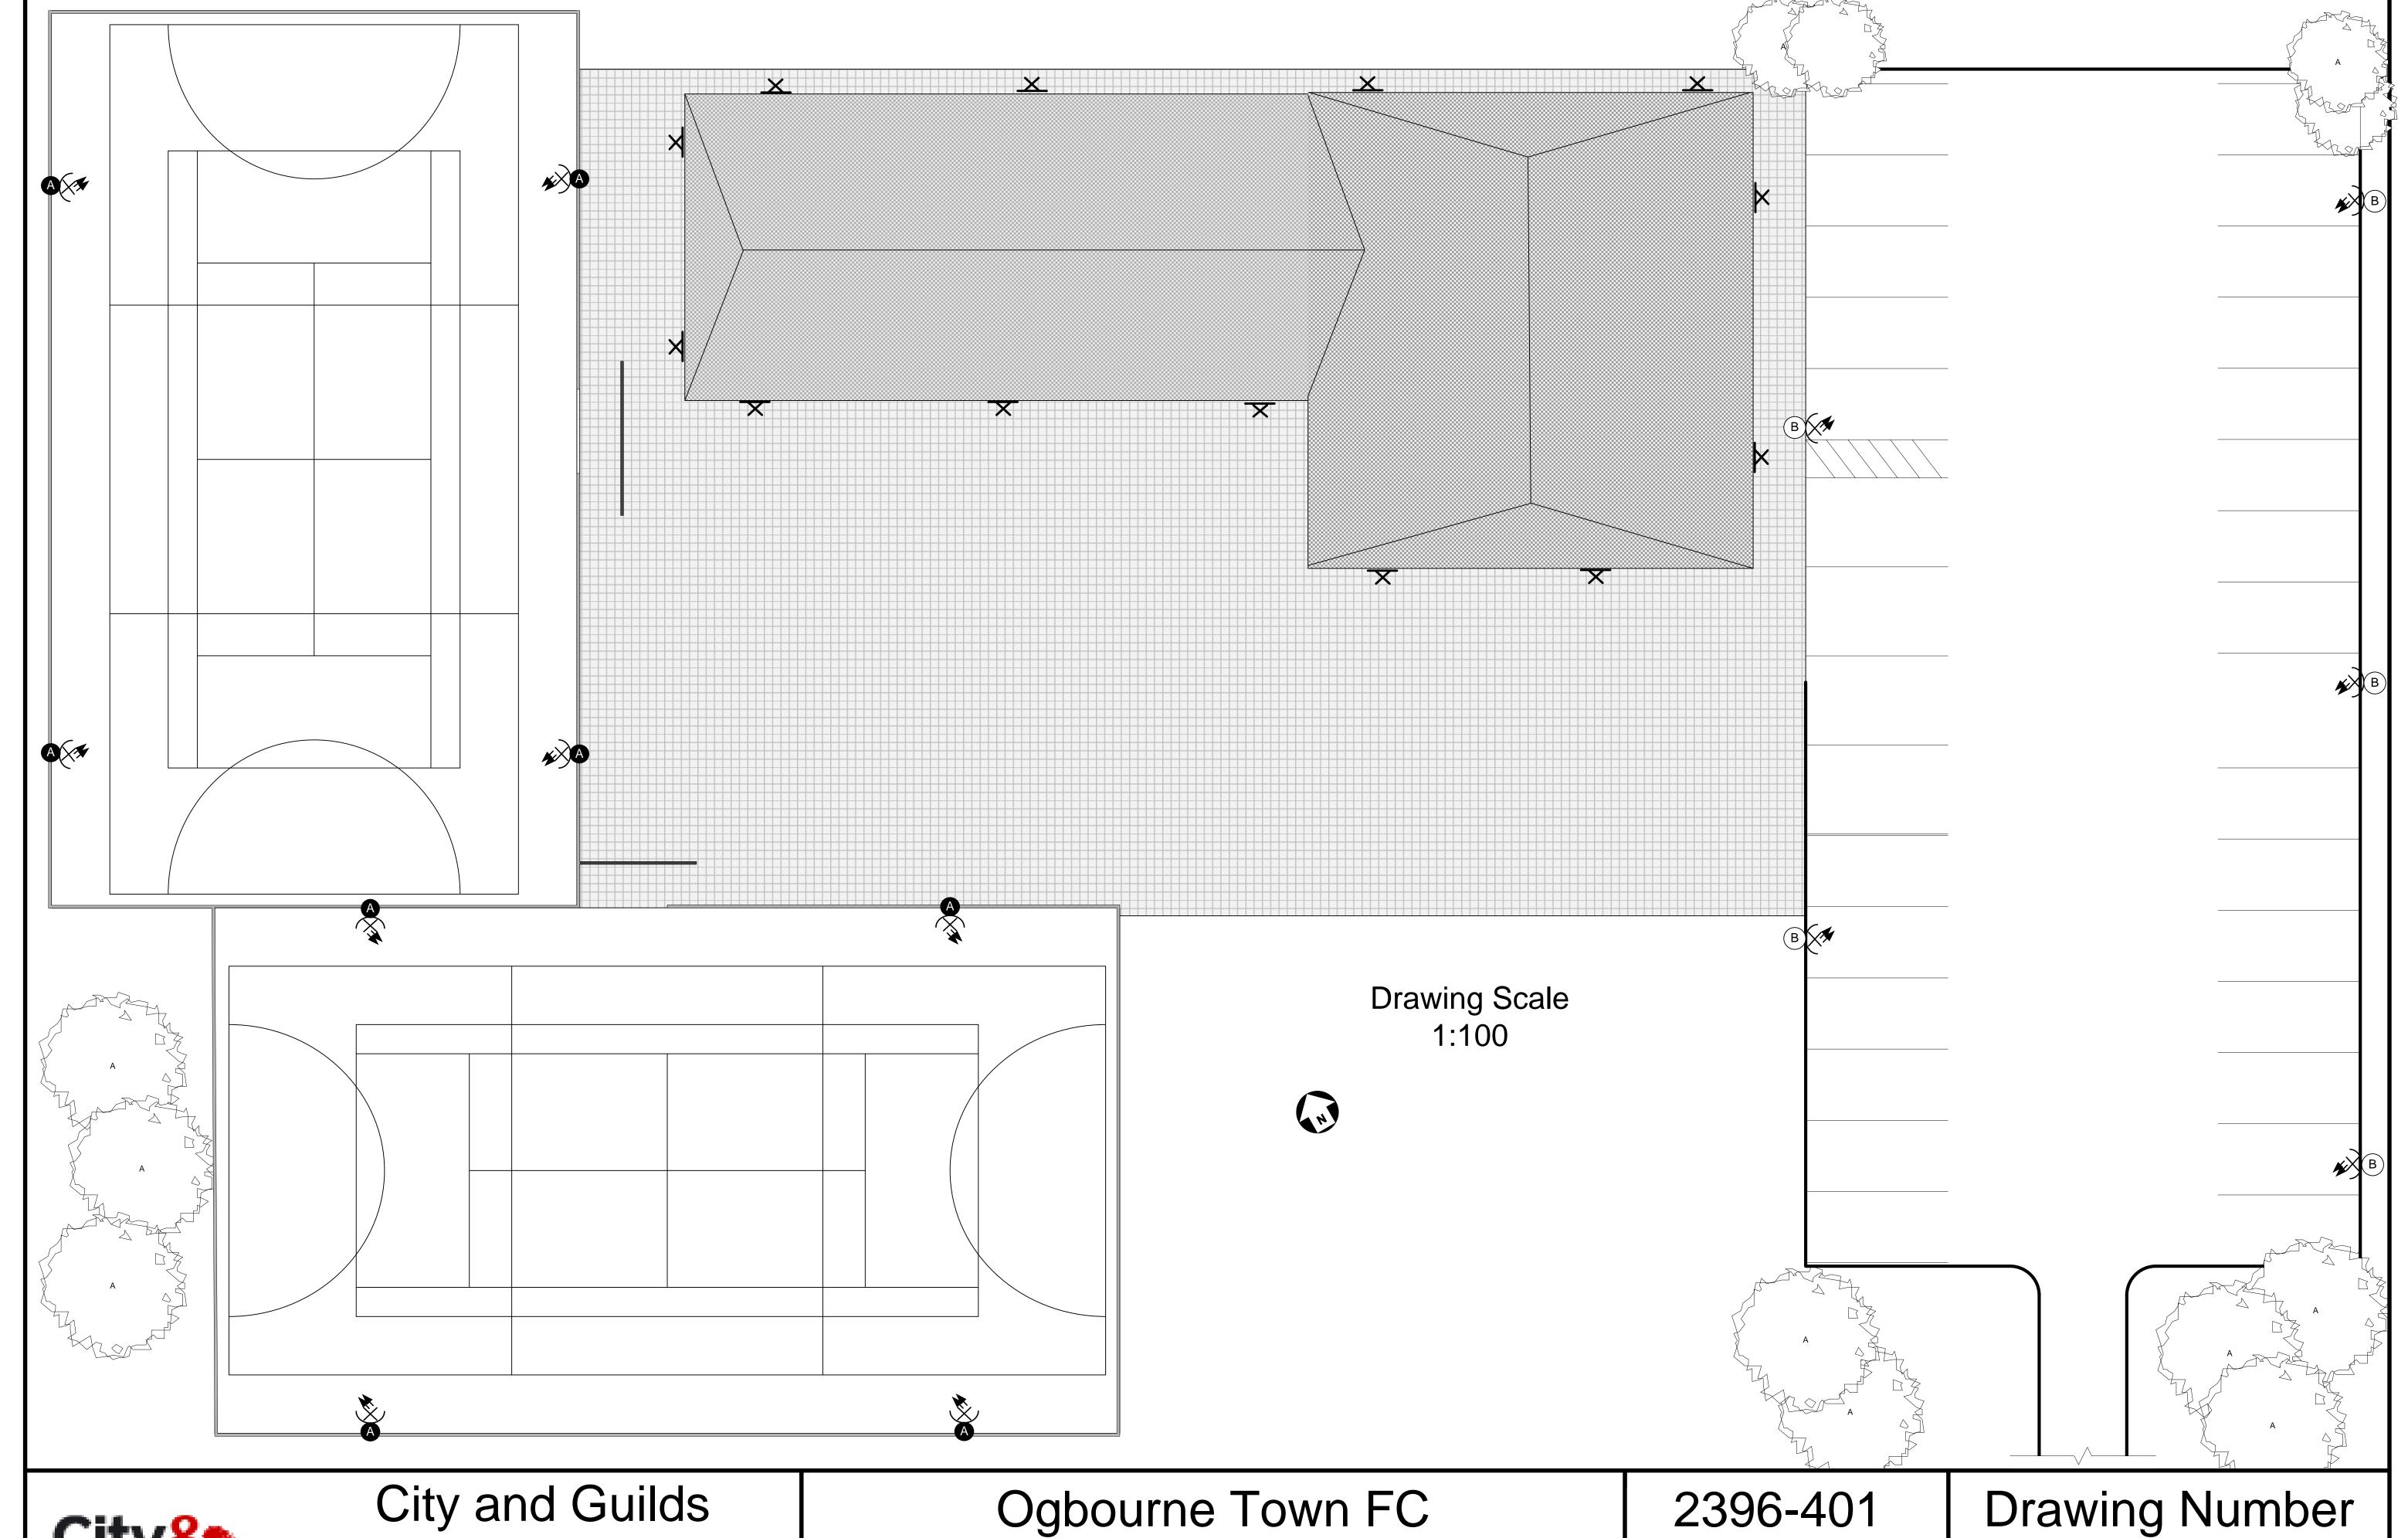



City and Guilds
2396 Design of
Electrical Installations

Ogbourne Town FC
Proposed New Changing Rooms,
Clubhouse & MUGAs

2396-401 Project 2018/2019

Drawing Number 2396-2018/19/2 Site Plan